




FURNITURE, FIXTURE & EQUIPMENT PATIO PLAN

1/4" = 1'-0"

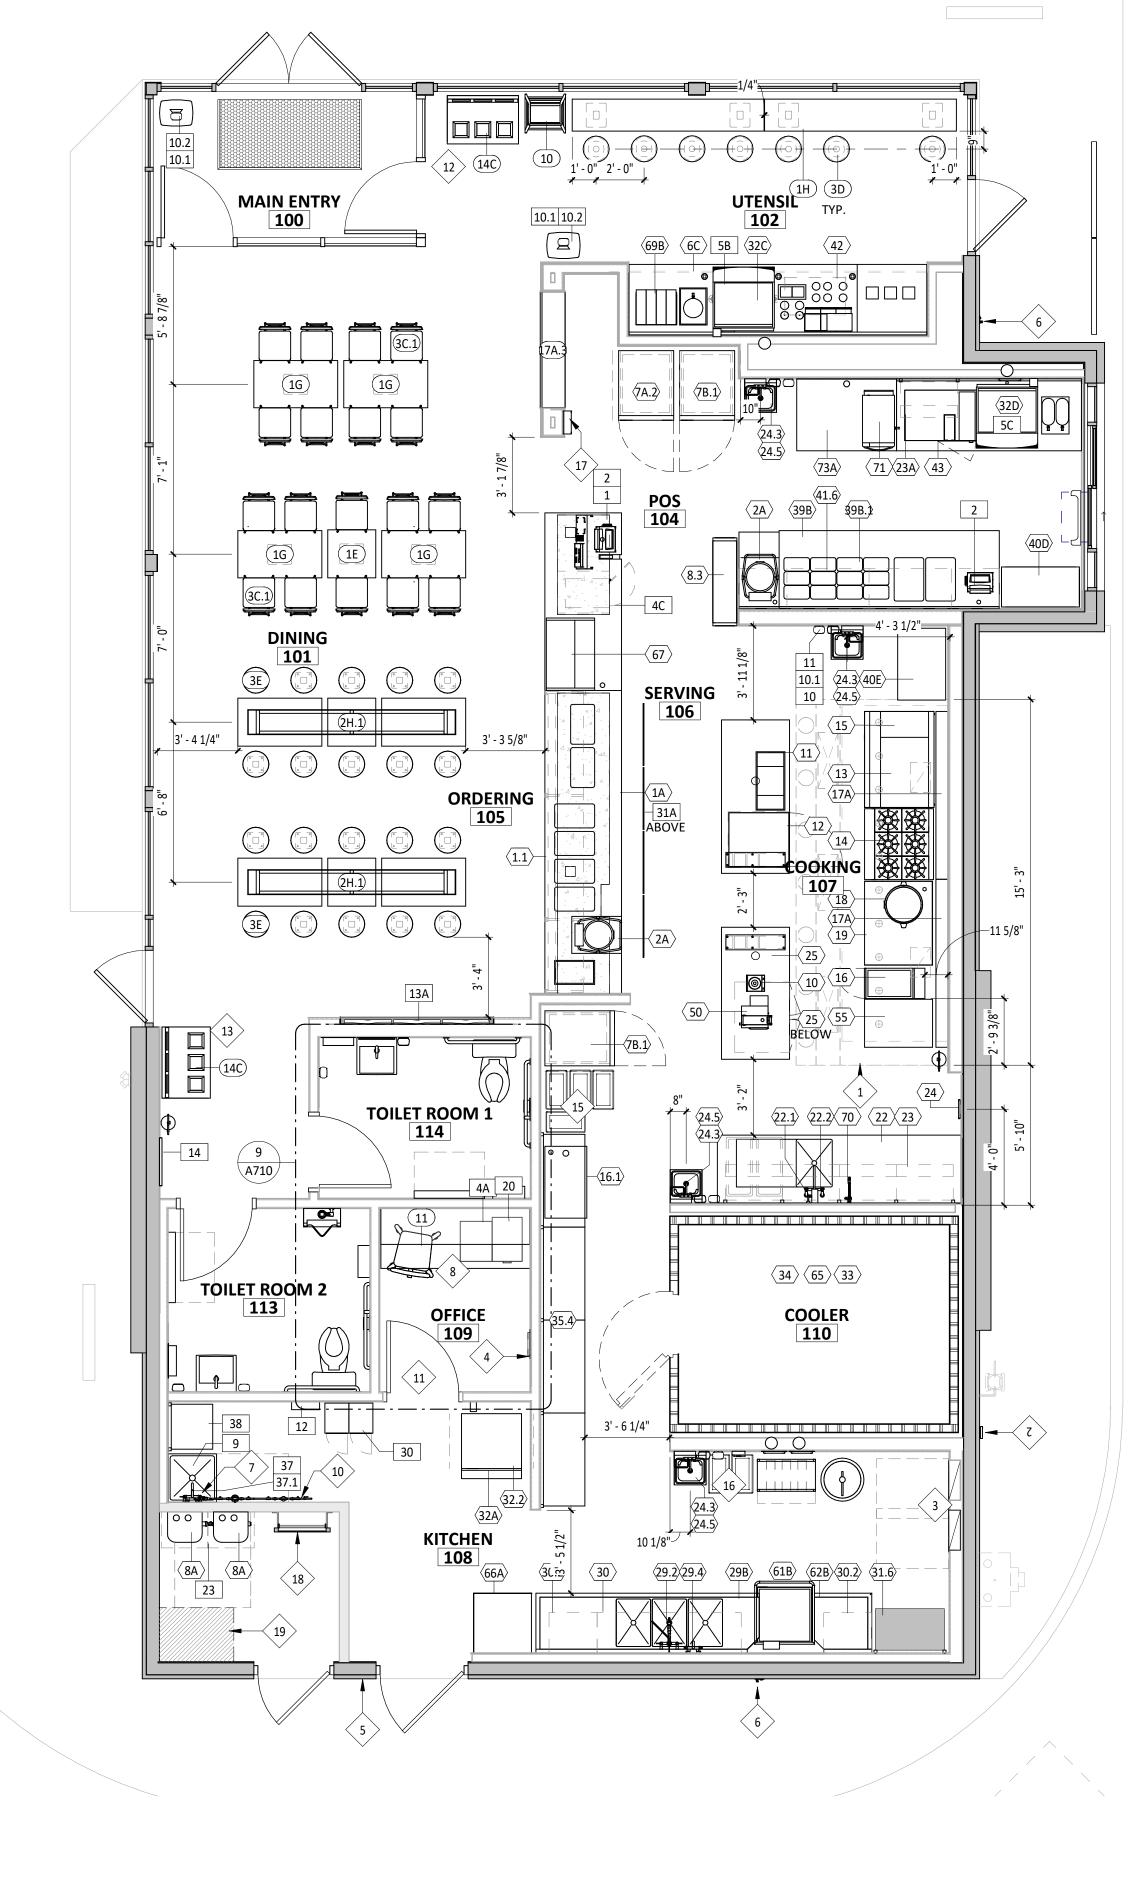

FURNITURE, FIXTURE, & EQUIPMENT PLAN

1/4" = 1'-0"



15 Ninth Avenue North, Hopkins, MN 55343 Phone: 952.941.8660/ www.wilkusarch.com

FIRM REGISTRATION

000000000

## REFERENCE ONLY NOT FOR

CONSTRUCTION

EXPIRES 00-00-0000

SIGNATURE
00 MONTH, YEAR

COPYRIGHT 2021
THIS DRAWING IS AN INSTRUMENT OF SERVICE
AND AS SUCH REMAINS THE PROPERTY OF
CHIPOTLE MEXICAN GRILL, INC.. PERMISSION FOR
USE OF THIS DOCUMENT IS LIMITED AND CAN BE
EXTENDED ONLY BY WRITTEN AGREEMENT WITH
CHIPOTLE MEXICAN GRILL, INC..



PO BOX 182566
COLUMBUS, OH 43218-2566
TELEPHONE: (614) 318-2482
INTERNET: WWW.CHIPOTLE.COM

"ARLINGTON HEIGHTS RELO"
600 E. RAND ROAD

Issue Record:	
	· ·
Revisions:	

Drawn: Checked:

K. BLISS K. MOAN

Project No.

Contents:

FF&E PLAN

A130

6 Cup Dispenser Dispense-Rite CHIP-ECL-3B KES KES; GC Installed At POS Counter 7A.2 Upright Beverage Cooler, Single Door, Hinge Right Hoshizaki America, Inc R1A-FGCR KES KES 7B.1 Upright Beverage Cooler, Single Door, Hinge Left Hoshizaki America, Inc R1A-FSL KES KES 8.3 M4.5 Chip Shelf Trimark Custom KES KES Vitamix 748 GC To Store In Walk-In Cooler Until Final Installation 11 | Carving Station - 77x34in - Horizontal Well - Right Delfield KES 77x34in Carving Station-RT KES 12 Undercounter Refrigerator Hoshizaki CRMR27-LP KES KES 13 Grill 48in - Natural Gas - Divider Left Woodstone WS-PL-48-36-4-CT-Left KES KES • • 13.1 Woodstone Grease Splash Guard Nationwide Fab; Marlo Mfg CHP-GCG-GSG KES KES Verify If Required 14 Range 6 Burner - Natural Gas Garland U36-6S KES KES 15 Woodstone Grill Stand 48x31in - Divider Left Woodstone 000-PL-STAND-CASTER KES KES 16 Fryer - Gas - Standard Efficiency 35CS KES KES • • Mounted On Legs, G.C. To Pin Front Legs To Floor 16.1 Grease Caddy Chipotle Grease Caddy KES KES American Welding 17A Cook Line Stand Off - 84x6 Nationwide Fab; Marlo Mfg CHP-7WS-6 KES KES Mount Top of Flat Surface at 33" AFF, Install Screws at Each Stud Location, Provide Blocking To Mount To Wall 18 Gas Rice Cooker Rinnai RER-55AS KES KES Final Connection by GC. RE: Mechanical Drawings 19 Rice Cooker Stand - Left Nationwide Fab; Marlo Mfg CHP-RCS-42ES-34 KES KES 22 Prep Sink - Corner - Left Trimark S1-122x34-US-FF-L KES GC 22.1 Prep Sink Faucet Big Flow Faucet T&S B-0293-01 GC KES 22.2 Prep Sink Vegetable Wash Faucet T&S B-0730 GC GC To Provide Connection For Chemical Dispensing Equipment KES 22.3 Prep Sink Drain Assembly T&S B-3950 KES; GC KES 23 4 Shelves - 120in Prep Sink Amco CHPPS120 KES KES Mount Bottom Of Standard At 50" AFF. Provide Plywood Blocking To Mount To Wall. 23A 2 Shelves - 30in Amco KES Mount Bottom Of Standard At 50" AFF. Provide Plywood Blocking To Mount To Wall. Custom KES 24.3 | Hand Sink Wall Mounted - Splash Both EHS-1RL-NF GC Provide Plywood Blocking To Mount To Wall **Universal Stainless** 4 KES 24.5 Kitchen Hand Sink Faucet Splash Mount T&S B-1146-04 GC 4 KES Nationwide Fabrication; Marlo Mfg Custom Table 66x34in KES KES 25 Rice Prep Table Island 66x34 Food Warming Equipment (FWE) KES 26 Hot Holding Cabinet - Double Door (Rice) HLC-16-CHP KES B-1033-12CRBJSK Substitute Sprayer B-0107-J-SWV 29.2 Dish Sink Add-A-Faucet w/ Pre-Rinse T&S KES GC T&S 29.3 Dish Sink Drain Assembly B-3950 KES KES; GC T&S B-2345-01-XX 29.4 Dish Sink Chemical Faucet KES GC GC To Provide Connection For Chemical Dispensing Equipment 29B 3 Comp Sink - 18x24in Bowls - 111 3/4in GC Nationwide Fabrication; Marlo Mfg S3-30x111.75x36.5-FF KES • KES 30 Shelving System - 3 Comp Sink Amco WST1879S KES Mount bottom of Standard At 56"AFF. Provide Plywood Blocking KES 30.2 | Shelving System - Dish Table Amco WST1879S KES Mount bottom of Standard At 56"AFF. Provide Plywood Blocking. Mount Tight To Dish Machine KES 31.6 Drying Racks 21x36x85in - With Vented Aluminum Covers Amco Custom KES Mount Bottom Of Standard At 12" AFF. Provide Plywood Blocking To Mount To Wall URC-5F KES 32.1A Ice Maker - Remote Condenser Hoshizaki KES Condensing Units To Be Secured To The Roof Per Code By GC Hoshizaki URC-9F 32.1B | Ice Maker - Remote Condenser KES KES Condensing Units To Be Secured To The Roof Per Code By GC B500SF 32.2 | Ice Maker - Storage Bin Hoshizaki KES KES 32.3 | Icemaker- Filter Cuno Bev 190 KES KES 32.4 Ice Maker - Scale Inhibitor Cuno CFS440-HT KES KES RGF IMSB TUV GC Refer To Installation Guide. When Installed At Utensil Counter, Mount Below Counter In Accessible Location. Refer To Plumbing Drawings. 32.5 | Ice Maker - Sanitizer 32A | Ice Maker For B.O.H. Ice Bin (Shorter) Hoshizaki KML-700MRJ KES KES Drain Ice Maker to Floor Sink, RE: Mech. Refrigeration By Tenant. 32C Ice Maker Mounted On Soda Machine - Air Cooled Hoshisaki KMD-530MAJ KES KES Drain Ice Maker to Floor Sink, RE: Mech. Refrigeration By Tenant. 32D Ice Maker Mounted On Soda Machine - Remote Air Cooled Hoshisaki KMD-530MRJ KES KES Drain Ice Maker to Floor Sink, RE: Mech. Refrigeration By Tenant. 33 Walk In Cooler 9x12x10ft 3in - Standard Manitowoc KAMC46-141-1EC-PCL-4 WCS GC • Refer To Plumbing and Mechanical Drawings; Refrigeration By Tenant; Remote Exterior Compressor Unit To Be Secured To Roof Per Code By GC 34 Walk-In Cooler Shelving System - 9x12x10 CHP912ER KES KES Cambro (Camshelving) 35.4 Dry Storage Racks 21x192x85in CHPDS485 KES KES Mount Bottom Of Standard At 12" AFF. Provide Plywood Blocking To Mount To Wall. Amco T&S 37 Mop Sink Faucet B-0660-BSTR GC KES • 37.1 Mop Sink Chemical Faucet T&S B-2345-01-XX GC KES • GC To Provide Connection For Chemical Dispensing Equipment CHPCS85 KES 38 6 Shelves - Chemical Storage Rack Amco KES Mount Bottom Of Standard At 12" AFF. Provide Plywood Blocking To Mount To Wall. 39B DML 2.0 130in – Right – W/POS & Cash Drawer Franke/Delfield KES DML 2.0\_RT-130x39 KES • Franke/Delfield KES 39B.1 DML 2.0 Wall Trim Package DML 2.0 Trim Kit KES KES 40D Holding Shelf Trimark TGS-39X20X80-B KES KES 40E M4.5 - Filler Stand At Range Select Stainless Custom KES 41.5 DML 2.0 Shelving - 130in - Top Shelf Franke/Delfield CH000A32 |Mount Bottom Of Shelf At 74 1/2" AFF. Provide Plywood Blocking To Mount To Wall 41.6 DML 2.0 Shelving - 130in - Bottom Shelf Franke/Delfield CH000A34 KES KES Mount Bottom Of Lowest Portion Of Shelf At 54 1/2" AFF. Provide Plywood Blocking To Mount To Wall. KES 42 Shelving System Under Counter Beverage Station WST1810CLR KES Mounted on (4) casters, All casters to be swivel type, Front (2) casters to have brake, Located under utensil counter ISS 43 Beverage Cooler Backbar 36in LP36X-SS(X) KES KES Glasstender KES 50 Food Processor CA-31 KES Sammic 55 Filler Table - 24x34in KES TS-24x34x36-US-0 Trimark KES 56 Beverage Table - Fast Lane TS-36x92.5x36 Trimark KES GC AM16SCB KES 61B Dish Machine (w/Pump) Hobart KES • CDT-30X30X36.5-B-L GC 62B Dish Table 30x30 Babington Technology KES 65 Utility Cart (Not Shown) 30SU-22-14-C4-TUBS-CUSTOM GC Provided As Part Of The WIC Shelving Select Stainless KES KES 66A Drop-Off Table - 29x30in TS-29x30x31-US-0 KES KES 67 Refrigerated Counter Case, Self-Serve CO3324R-UC KES Structural Concepts GC 69B M4.0 - Simplicity Bubbler Mini-Quad Crathco CS-4E-16 KES T&S B-0432 MOD 70 Speed Fill Faucet GC KES Turbochef Sota Touch KES 71 Quesadilla Press KES KES 50X36X36 73A 50" TurboChef Table Trimark KES UTILITY UTILITY FURNISHED INSTALLE DESCRIPTION ELEC GAS WATER SEWER REMARKS TAG QTY BY D BY **DESCRIPTION** QTY FURNISHED BY INSTALLED BY ELEC GAS WATER SEWER TMS Point of Sale Display 1 GC Installed at POS Station M4.0 - Table 24x24in - Rectangular Base 1 TMS GC 2 Point-Of-Sale System TCC Coordinate Requirements With Tenant and Elec. Drawings M4.0 - Table 24x42in, Rectangular Base (Centered) 4 TMS GC 4A B-Rate (Standard Safe) 1 TS GC Install in Office, Bolt to Office Floor Slab M4.0 - Community Table - Low - Window - Length Varies 2 TMS GC 1 1 TSS GC 4C Smart Safe TSS To Be Installed On Curb Under Serveline, Bolt to Curb Under Serveline POS M4.0 - Bar Height Table 10-Top, With Footrest 2 TMS 5B | Soda Dispenser - With Air-Cooled Ice Maker SPS 1 SPS Drain to Floor Sink, Tenant Millwork Supplier to Provide (2) Adjustable Legs to Support Dispenser From U M4.0 - Dining Room Chair 18 TMS GC Soda Dispenser - With Remote Air-Cooled Ice Maker 1 7 SPS SPS • Drain to Floor Sink, Tenant Millwork Supplier to Provide (2) Adjustable Legs to Support Dispenser From M4.0 - Marshmallow Stool - Fixed TMS GC Soda System Syrup Rack with Carbonator on Stainless Steel 1 SPS SPS M4.0 - Bar Stool - Fixed 20 TMS GC Shelf Wall Mounted at 89" AFF M4.0 - Beverage Counter - With Trash - 4" Splash - 149" TMS GC CO2 7A Bulk CO2 Tank 1 CO2 Provide (1) 3/8inØ X 2in Embedment Hilti Kwik Bolt Tz Per Leg GC Drain Water Heater To Floor Drain, RE: Mech. 8A Gas Tankless Water Heater 2 GC Child's High Chair 1 1 9 Mop Sink, See Plumbing Drawings GC See Plumbing Drawings Office Chair, By Tenant GC 10 Touch-Free Soap Dispenser WA GC Patio Chair - Bistro 20 KES 4 6 10.1 Hand Sanitizer Dispenser WA GC 24in Round Bistro Table GC KES 10.2 Hand Sanitizer Stand WA 30in Square Bistro Table GC 2 GC 4 KES 4 WA TMS GC 11 Paper Towel Dispenser, Bobrick B262 Provide Plywood Blocking to Mount to Wall

MODEL NO.

12 Pan Serve Line POS RTD\_241x38.5in (Right)

Custom-R

See MEP Sheets for Details

A2

QTY

**FURNISHED BY** 

TMS

KES

KES

**INSTALLED BY** 

TMS/GC KES; GC

KES

TAG

2A Tortilla Warmer

12 First Aid Kit

14 License Frame

16 Fire Extinguisher Package

16B Fire Extinguisher Type K

23 Backflow Preventer

24 LaunchPort Wall Station

28 Mop Strip (Not Shown)

31A 21inx31in Menu System

32 CO2 Alarm

30 Lockers - 2 Wide x 5 High

16A Fire Extinguisher Type ABC - B456

19 Hat & Coat Strips (Not Shown)

20 2-Drawer File Cabinet, By Tenant

33A M4.0 - Pick-Up Sign - Single Faced - Flush Mounted - Face 1 TSV

13A M4.0 Artwork Panels, 6 Panel System

1

1

1 1

1

1

TAS

GC

GC

GC

WA

KES

TMB

CO2AS

GC

1.1 Sneeze Guard Serve Line 12 Pan (Right)

1A M4.0 - Front Serve Line - 12 Pan - RTD - POS Right

DESCRIPTION

**MANUFACTURER** 

Delfield

Caliente Industries

REMARKS One Coat Hook Per Two Seats, Confirm Mounting Location With Shop Drawings Align Seat With Seam Perpendicular To Table Edge Align Seat With Seam Perpendicular To Table Edge • Coordinate Floor Drain Installation with Utensil Counter Installation, Bins Provided by Tundra in Smallwares Package Provided by EMU America, Contact: Carol Hughes (303-744-3200) Provided By EMU America, Contact: Carol Hughes (303-744-3200) Provided By EMU America, Contact: Carol Hughes (303-744-3200) 3 Bin Trash/Recycling Surround - Exterior Bins Provided by Tundra in Smallwares Package TMS GC M4.0 - 3 Bin Trash/Recycling Surround - Interior 2 Bins Provided by Tundra in Smallwares Package GC Patio Umbrella KES Provided By EMU America, Contact: Carol Hughes (303-744-3200) GC Accessible Patio Table 1 KES GC MOPUS Shelving - 58" TMS GC To Provide Blocking In Walls At The Ends Of The MOPUS Shelf To Secure Shelves, Wood Edge Of The Shelves To Face The Dining Room

REMARKS

15 Ninth Avenue North, Hopkins, MN 55343 Phone: 952.941.8660/ www.wilkusarch.com

> FIRM REGISTRATION 000000000

## REFERENCE ONLY

EXPIRES 00-00-0000

SIGNATURE 00 MONTH, YEAR

COPYRIGHT 2021 THIS DRAWING IS AN INSTRUMENT OF SERVICE AND AS SUCH REMAINS THE PROPERTY OF CHIPOTLE MEXICAN GRILL, INC.. PERMISSION FOR USE OF THIS DOCUMENT IS LIMITED AND CAN BE EXTENDED ONLY BY WRITTEN AGREEMENT WITH CHIPOTLE MEXICAN GRILL, INC..



TELEPHONE: (614) 318-2482 INTERNET: WWW.CHIPOTLE.COM

> ELO "ARLINGTON HEIGHTS R 600 E. RAND ROAD ARLINGTON HEIGHTS, IL (

3673

STORE NO.:

-	
Drawn:	Checked:
DESIGNER	K. MOAN
Project No.	

FF&E SCHEDULES

REMARKS		TAG
Installed at POS Station		
Coordinate Requirements With Tenant and Elec. Drawings		
Install in Office, Bolt to Office Floor Slab		
To Be Installed On Curb Under Serveline, Bolt to Curb Under Serveline POS		
Drain to Floor Sink, Tenant Millwork Supplier to Provide (2) Adjustable Legs to Support Dispenser From Under The Utensil Counter		
Drain to Floor Sink, Tenant Millwork Supplier to Provide (2) Adjustable Legs to Support Dispenser From Under The Utensil Counter		
	FURNITURE	3E
	$\mathbf{C}$	6C
Provide (1) 3/8inØ X 2in Embedment Hilti Kwik Bolt Tz Per Leg		
Drain Water Heater To Floor Drain, RE: Mech.		
See Plumbing Drawings		
		12
	Z	13A
	~	13B
Provide Plywood Blocking to Mount to Wall		
Confirm Location With Chipotle CM Prior To Installation		
		15
Provide Plywood Backing In Wall At License Frame Location, Refer To Arch. Floor Plans And Elevations For License Frame Location.		16
Fire Extinguisher Package includes (2) Type 'ABC' and (1) Type 'K' Fire Extinguishers to be mounted in locations specified by the Fire Marshal. Provide plywood backing at specified locations.		
Mount in locations specified by the Fire Marshal. Provide plywood backing at specified locations.		
Mount in locations specified by the Fire Marshal. Provide plywood backing at specified locations.		
Provide Plywood Blocking to Mount to Wall		
By Tenant		
See MEP Sheets for Details		
Tablet By Tenant		
Provide Plywood Backing To Mount To Wall, 2 Hole At Mop Basin and 6 Hole In Kitchen		
Mount At 18" AFF, Refer to Electrical Drawings for Additional Details		
	ı	

UTILITY

Installed On Concrete Curb

GC To Store In Walk-In Cooler Until Final Installation

ELEC GAS WATER SEWER